



Symbol	Label	Image	QTY	Catalog Number	Description	Lamp	Number Lamps	Lumens per Lamp	LLF	Wattage	Polar Plot
□	A		9	DSX0 LED P1 27K 8000 AFR HS EGS-F	Series Size 0 Area Luminaire P1 Performance Package 2700K CCT 80 CRI Automotive Front Row Houseside Shield Forward External Glare Shield		1	3074	0.9	33.21	
□	B		1	DSX0 LED P1 27K 8000 AFR HS EGS-F	Series Size 0 Area Luminaire P1 Performance Package 2700K CCT 80 CRI Automotive Front Row Houseside Shield Forward External Glare Shield		1	3074	0.85	66.42	

Statistics						
Description	Symbol	Avg	Max	Min	Max/Min	Avg/Min
Calc Zone #1	+	1.3 fc	5.9 fc	0.1 fc	59.0:1	13.0:1
Calc Zone #2	+	0.1 fc	0.6 fc	0.0 fc	N/A	N/A

Luminaire Locations										
No.	Label	Location					Aim			
		X	Y	Z	MH	Orientation	Tilt	X	Y	Z
1	A	312.67	377.53	15.00	15.00	178.07	0.00	312.71	376.39	0.00
2	A	385.93	342.77	15.00	15.00	270.00	0.00	384.79	342.77	0.00
3	A	385.80	301.30	15.00	15.00	270.00	0.00	384.65	301.30	0.00
4	A	385.80	259.99	15.00	15.00	270.00	0.00	384.65	259.99	0.00
5	A	385.80	222.83	15.00	15.00	270.00	0.00	384.65	222.83	0.00
6	A	326.89	331.02	15.00	15.00	180.00	0.00	326.89	329.88	0.00
7	A	326.74	337.73	15.00	15.00	0.00	0.00	326.74	338.87	0.00
8	A	327.01	212.08	15.00	15.00	0.00	0.00	327.01	213.22	0.00
9	A	327.01	201.79	15.00	15.00	180.00	0.00	327.01	200.64	0.00
1	B	326.96	276.35	15.00	15.00	0.00	0.00			

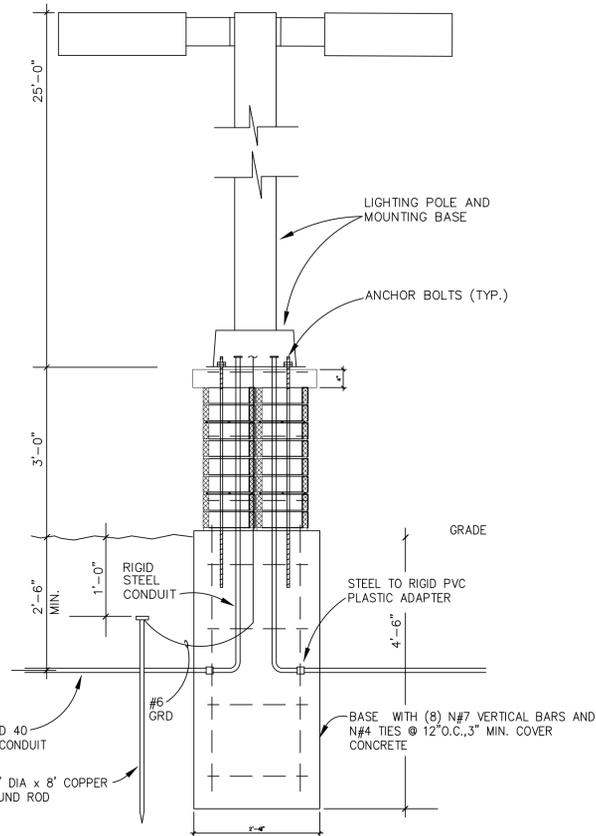

LIGHT POLE

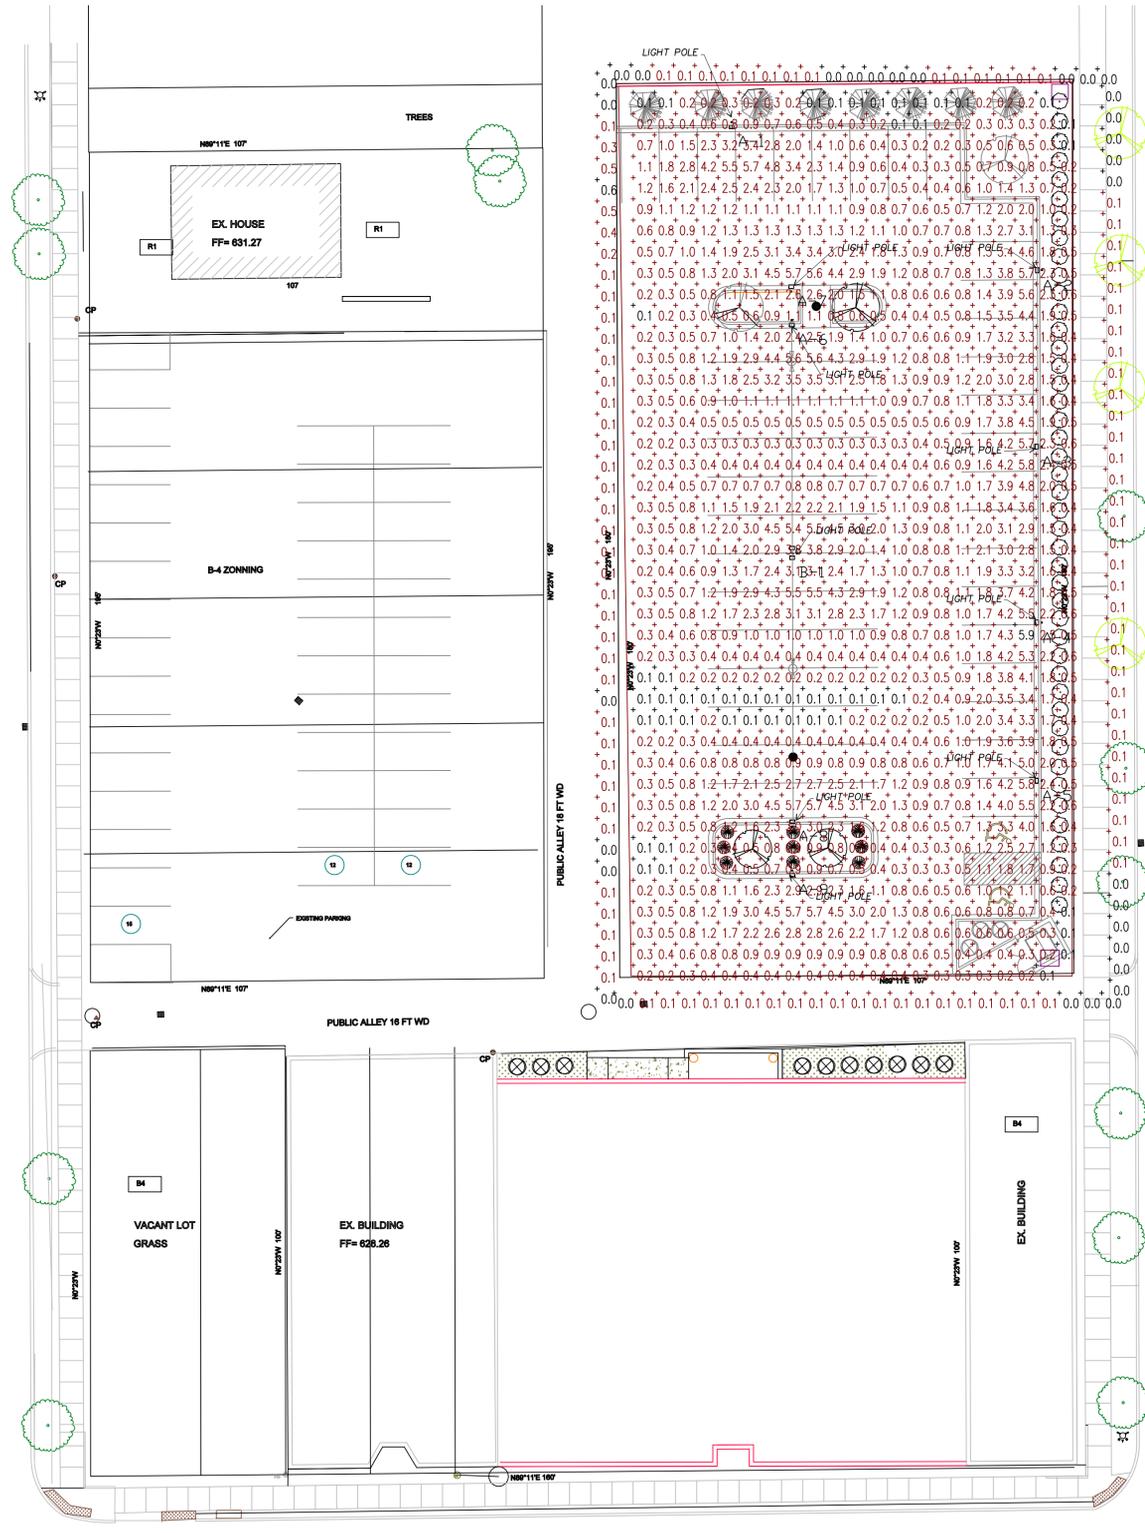

E Mc NICHOLS RD

66 FT WD

ELECTRICAL SITE PLAN

1" = 20'-0"

SUNSET ST
60 FT WD



Atelier Architect, P.C.

6346 Orchard Lake Rd Suite 16
West Bloomfield, MI 48322-2327
Phone: 248-885-8286
Fax: 248-885-8287
e-mail: Info@atelierarchitect.com

Project

DURGA TEMPLE

Project No.

2022-23

Certification

I here by certify that the construction documents contained herein were prepared under my direct supervision and I am a registered architect under the laws of the State of Michigan.



Sheet Title

ELECTRICAL SITE PLAN

Issued Date

PERMIT	03 / 08 / 2024
REVISION 1	07 / 11 / 2024
REVISION 2	10 / 30 / 2024
REVISION 3	06 / 02 / 2025

Sheet No.

E-1