


LUMINAIRE SCHEDULE						
SYMBOL	CATALOGUE NUMBER DESCRIPTION	BALAST	VOLT	LAMP	LUMENS	WATTS
□ A	LITHONIA 2GT8 4 32 A12 MVOLTI/4 GEB10IS NY	1	120-277	4 LAMP 32-WATT T8		32
▬ B	LITHONIA CSS L48 4000LM MVOLT 40K 80CRI 4 MVOLT LED Strip Light	1	120-277		4298	35.3
○ C	LAKELAND LK1024L	1	120-277	4-60W A19 (240W) 1-100W PAR38 (100W)		
○ D	8" DIA. DOWN LIGHT, 75W					
○ E	6" DIA. DOWN LIGHT, 75W					
⊕ X	LLC2URW12R LLC2 Series, Universal Face, Red Letters, White Housing, 12 W Remote Capacity		120/277	5.4 W, T-5 Tungsten lamp		
⊕ EM	E118T6WE1 Series, 6 V 18 W, 6 W Tungsten Lamps, White		120/277	6 W, Tungsten lamp		
⊕ EL	Remote Head Mounting Plate, Cast Aluminum, Weatherproof, Single Head, Fits 3 or 4" Round Box Remote Head, NEMA Rated, Par 35, 6 V 18 W Tungsten		120/277	20 W MR16 Halogen		

- LIGHTING FIXTURES SCHEDULE NOTES:**
1. PROVIDE FIXTURE WITH ENERGY SAVING BALLAST
 2. COORDINATE EXACT LOCATION OF FIXTURES WITH PLAN
 3. PROVIDE FIXTURE WITH UL-WET LOCATION PLAN
 4. PROVIDE LOW TEMPERATURE BALLAST FOR EXTERIOR FIXTURES
 5. FIXTURES SHALL BE HUNG WITH AIRCRAFT SUSPENSION CABLE (ZACCHI M100) WITH TOP OF FIXTURE AT 11'-6"
 6. USE PSL 600 BALLASTS IF ADDITIONAL COVERAGE IS REQUIRED
 7. IF NECESSARY TO PROVIDE MINIMUM 1 FOOT-CANDLE ALONG PATH OF EGRESS

INSTALL AN OCCUPANT SENSOR TURNING LIGHTS OFF WITHIN 30 MINUTES OF AN OCCUPANT LEAVING A SPACE

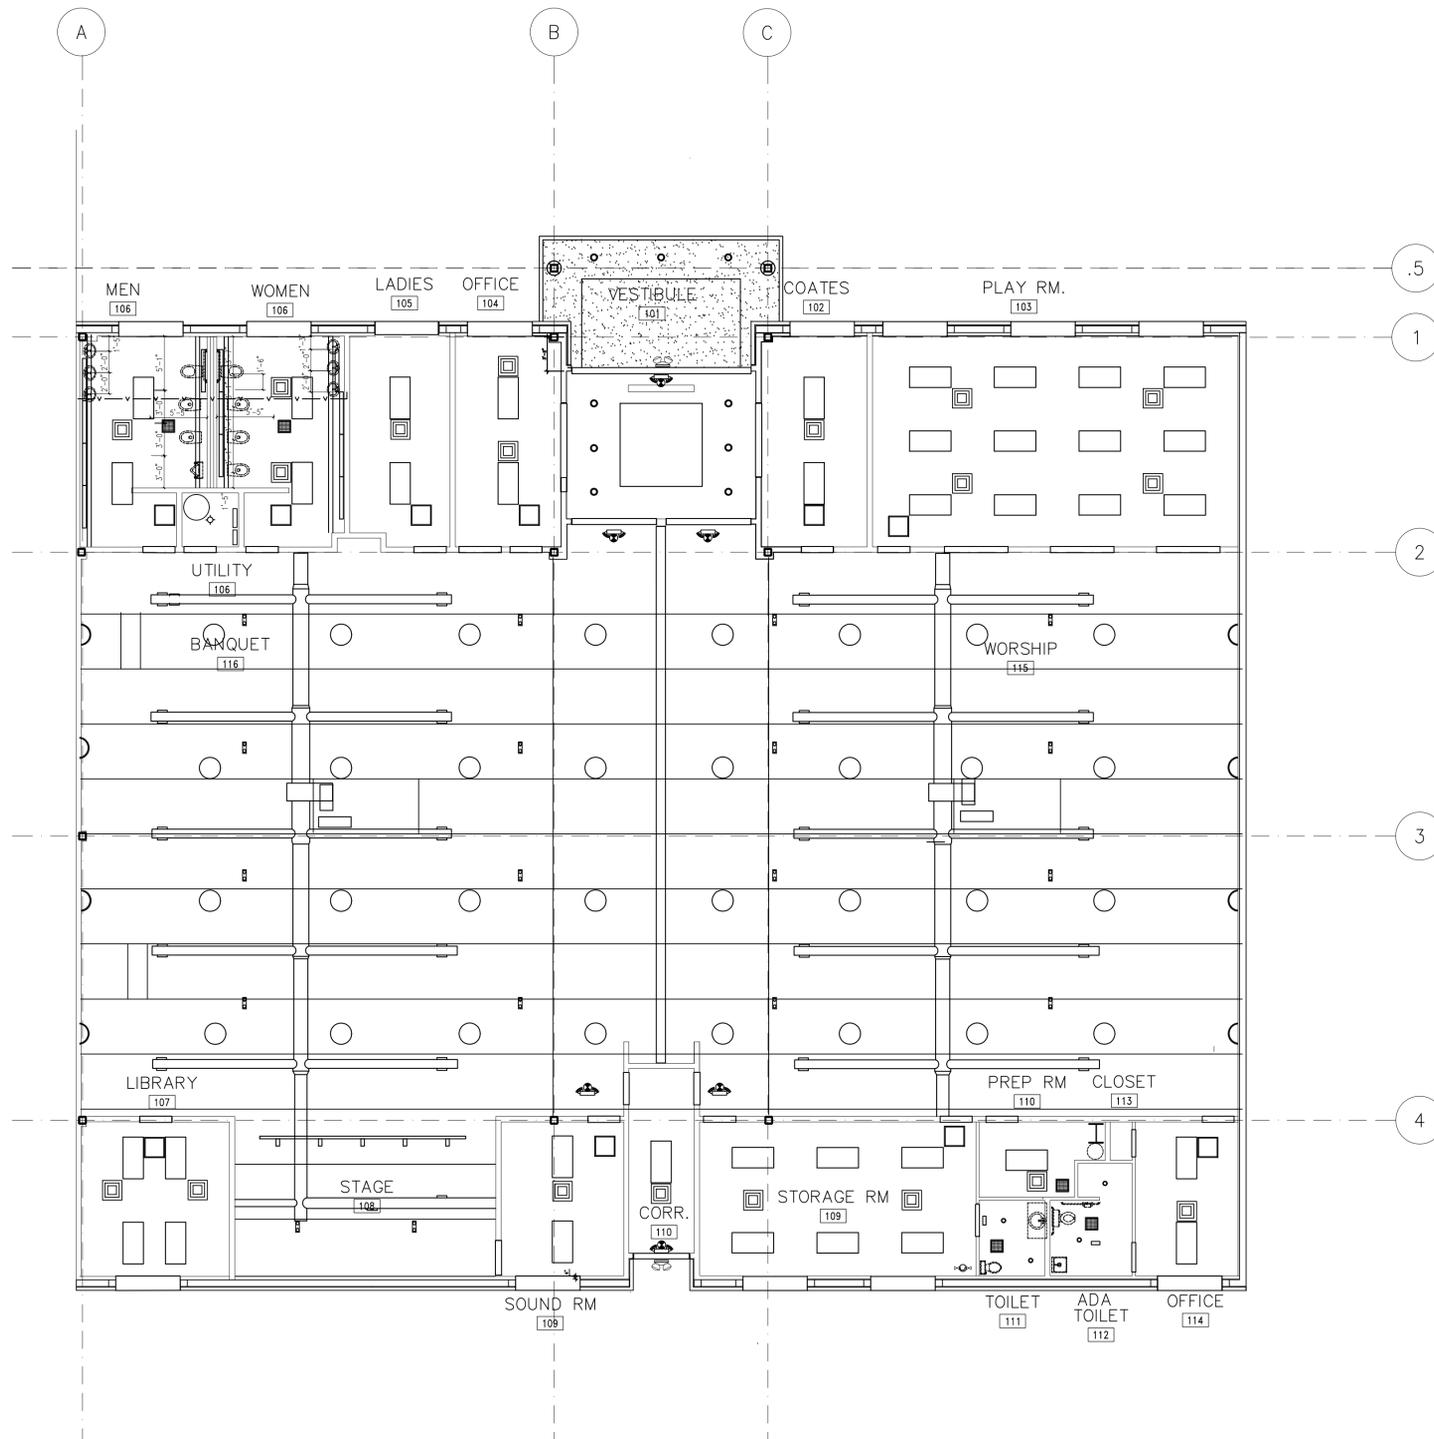

LIGHTING PLAN

1/8" = 1'-0"



Atelier Architect, P.C.

6346 Orchard Lake Rd Suite 16
West Bloomfield, MI 48322-2327
Phone: 248-885-8286
Fax: 248-885-8287
e-mail: Info@atelierarchitect.com

Project

DURGA TEMPLE

Project No.

2022-23

Certification

I here by certify that the construction documents contained herein were prepared under my direct supervision and I am a registered architect under the laws of the State of Michigan.



Sheet Title

LIGHTING PLAN

Issued Date

PERMIT	03 / 08 / 2024
REVISION 1	07 / 11 / 2024
REVISION 2	10 / 30 / 2024

Sheet No.
E-2