


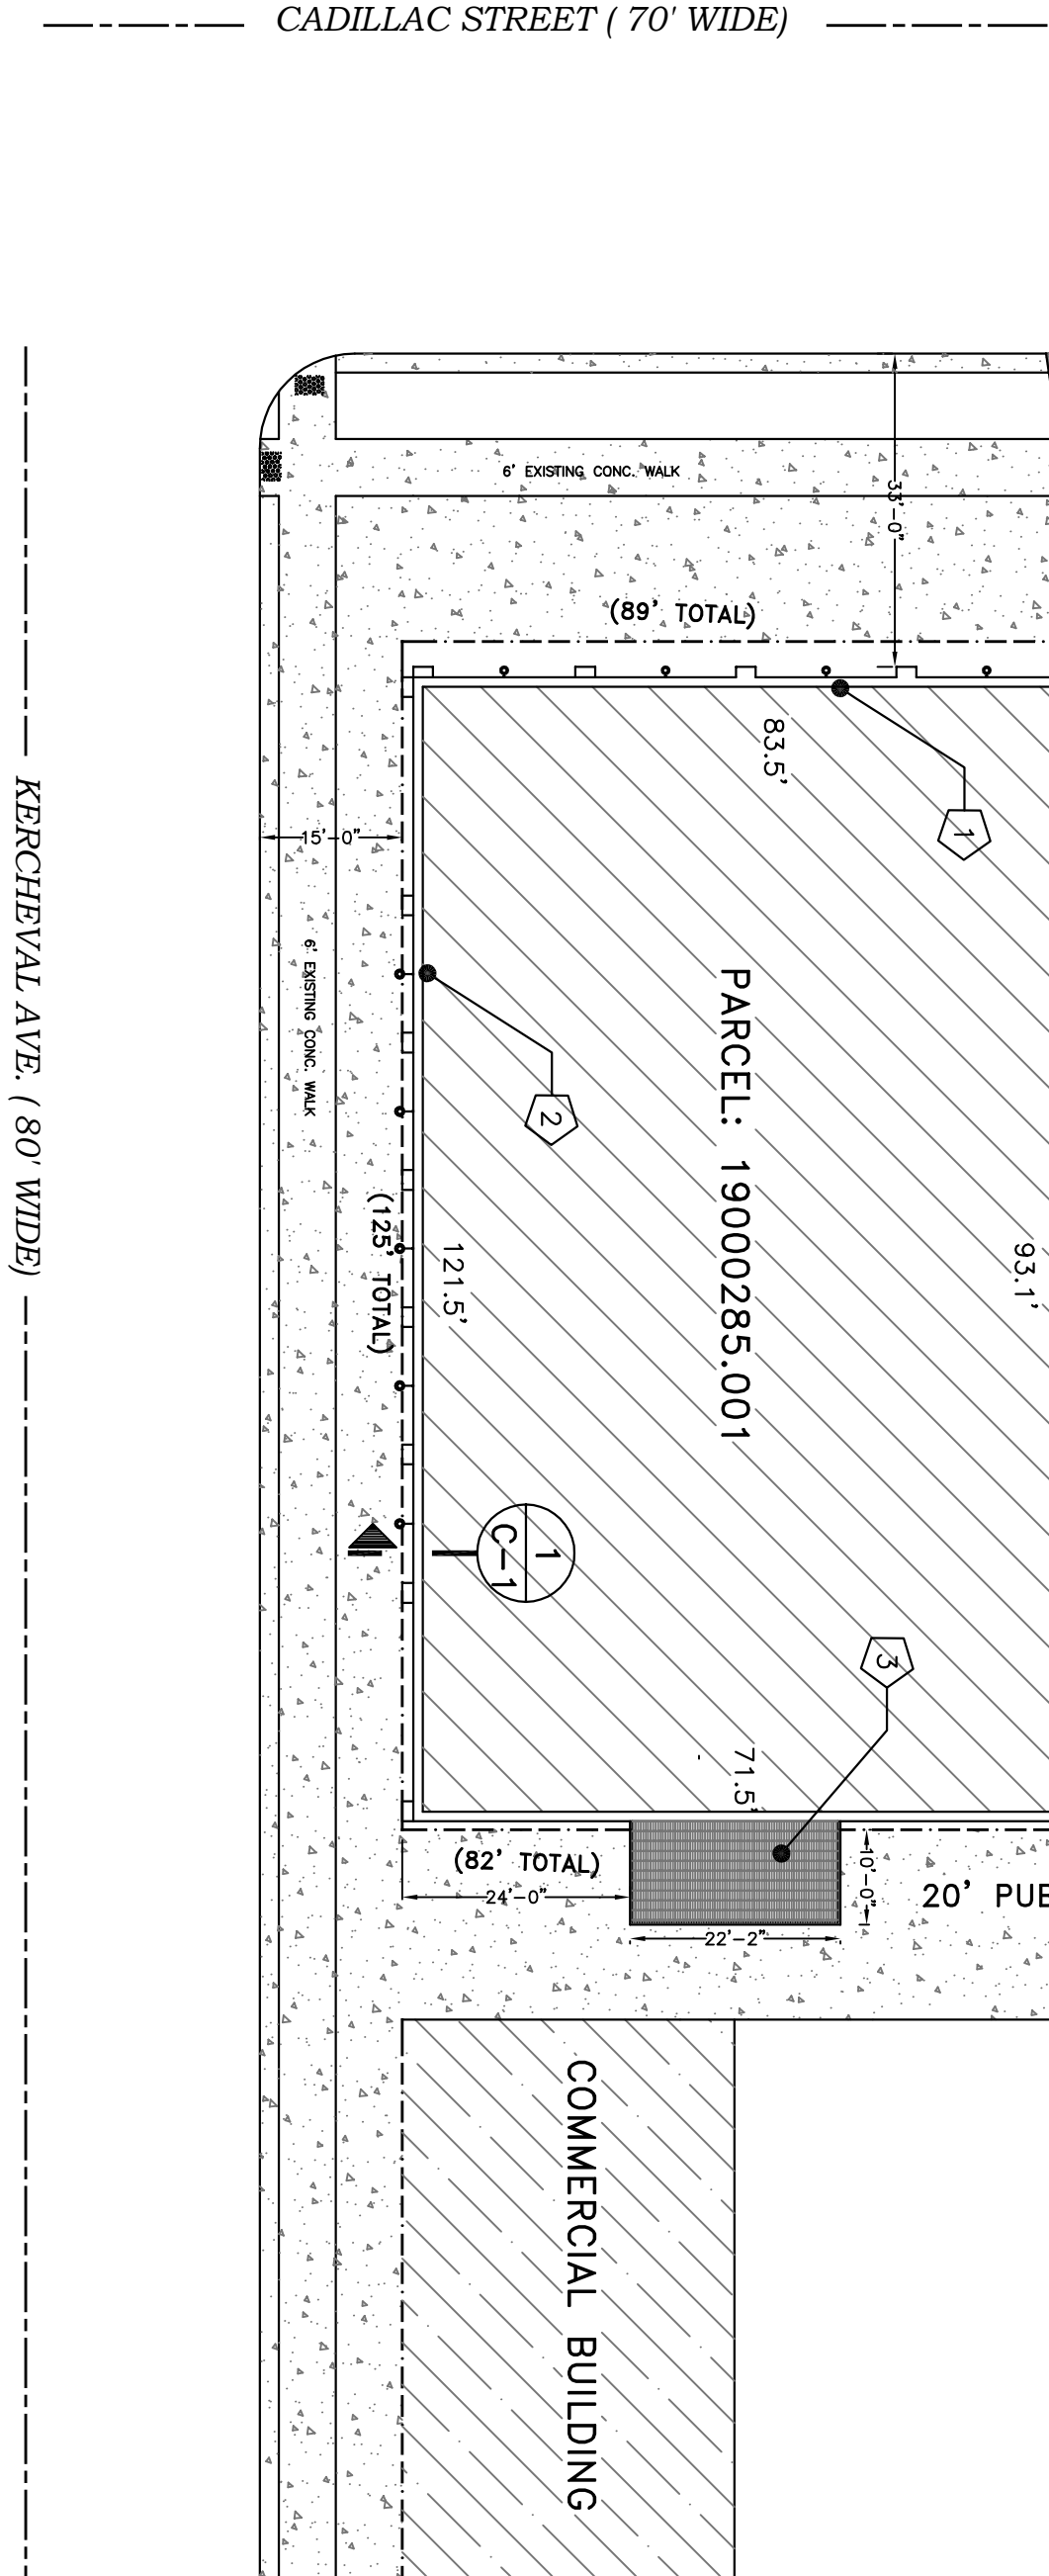

EXISTING SITE PLAN

SCALE: 1"=20'



PLATFORM IN RELATION TO ALLEY



WALL LIGHT ABOVE RIGHT OF WAY





HVAC EQUIPMENT ON PLATFORM

SCOPE OF WORK

- 1 TYPICAL BUILDING LIGHT EXTENDED 10" FROM INNER BUILDING WALL
- 2 TYPICAL WALL BUILDING LIGHTS EXTENDED 23" FROM INNER BUILDING WALL AND 10' ABOVE THE CONCRETE WALK
- 3 .11' X 22' RAISED PLATFORM FOR BUILDING HVAC SUPPORT. STEEL FRAME WITH STEEL GRATING FLOOR. 2.5" CIRCULAR TUBE RAILING 43" HIGH. CANOPY ELEVATION FROM ALLEY CONC. FLOOR IS 18'


TOP VIEW OF WALL LIGHT

NOT TO SCALE

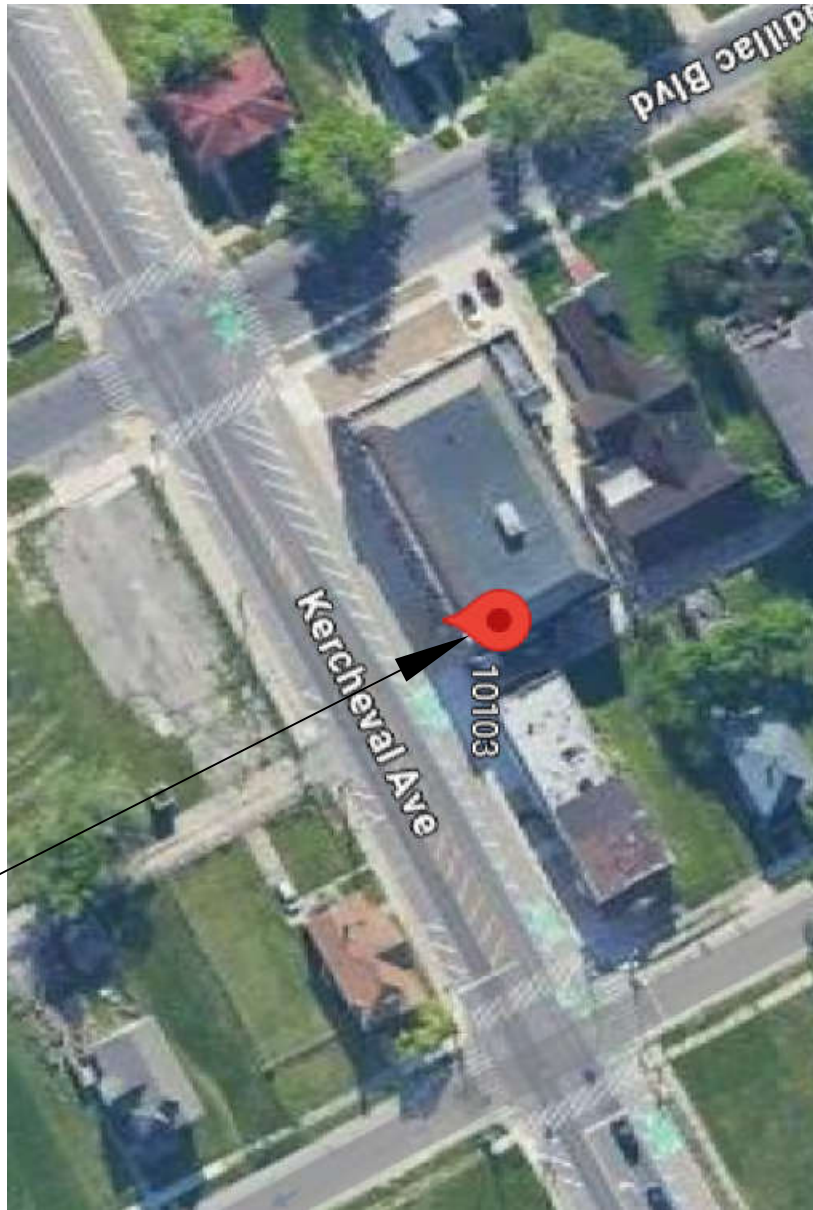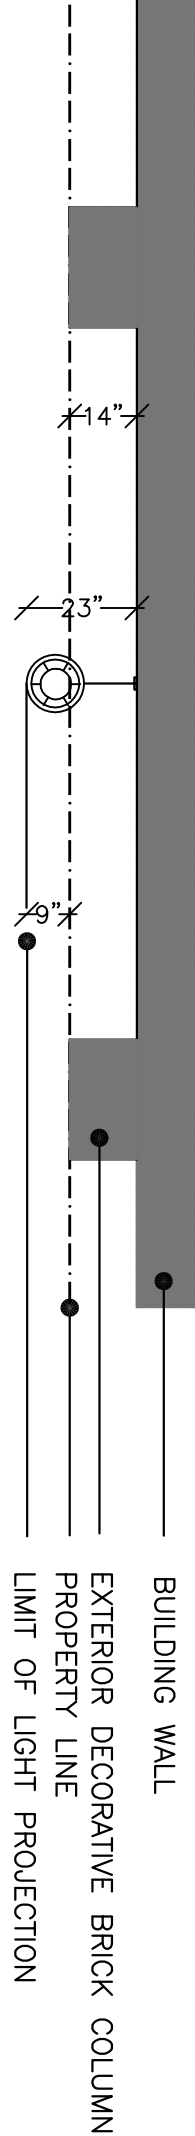

SITE

VICINITY MAP
NOT TO SCALE

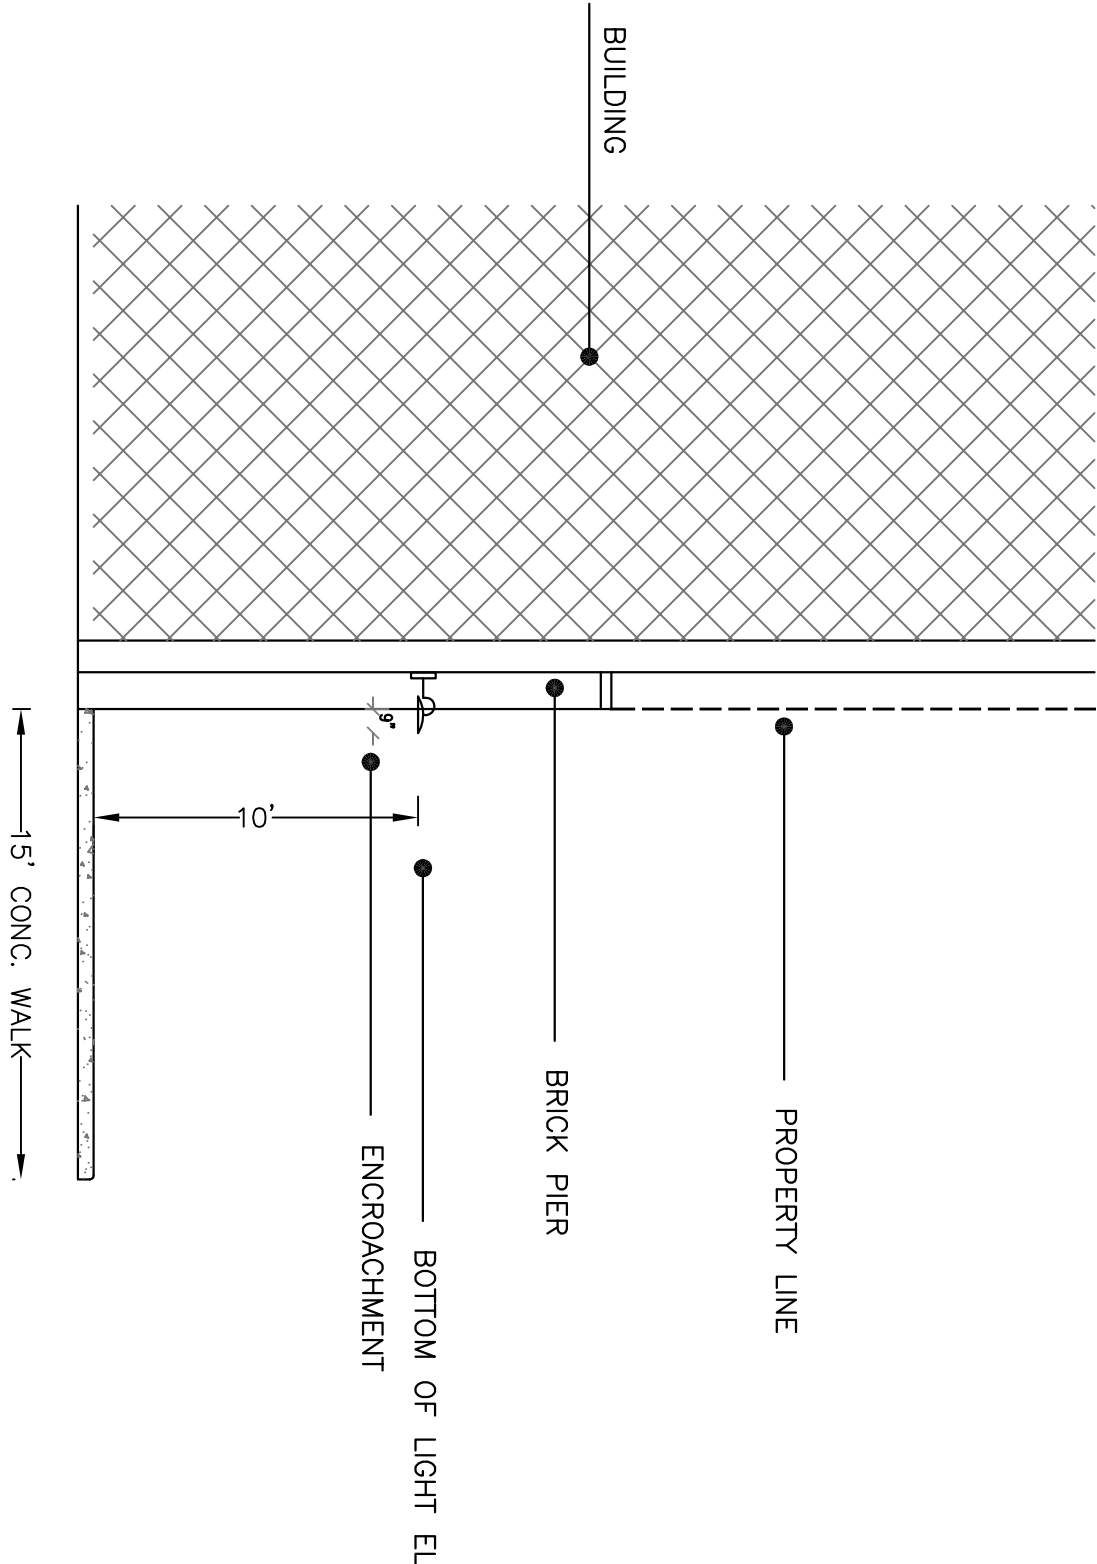


1
C-1
NOT TO SCALE

A: 15"
B: 12.25"
C: 23"



SPECIFICATION OF WALL LIGHTS INSTALLED

SCALE:	DATE:	ACAD FILE:
AS NOTED	08-28-2025	10103 KERCHEVAL
DRAWN BY	DATE	ISSUED FOR
J.S.	01-28-2026	DPW APPLICATION FOR ENCROACHMENT IN THE RIGHT OF WAY
DESIGNED BY		
J.S.		
CHECKED BY		
J.S.		

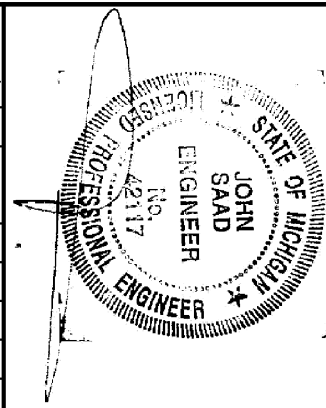

SHEET TITLE:	EXISTING SITE PLAN
	APPLICATION FOR ENCROACHMENT IN THE RIGHT OF WAY OF AN EXISTING SITE LOCATED AT 10103 KERCHEVAL, DETROIT MICHIGAN
	APPLICANT: EPIPHANY DETROIT LLC 10103 KERCHEVAL, DETROIT, MICHIGAN 48214 EPIPHANYDETROIT@ATT.NET

HANNA ENGINEERING AND CONSULTING
Planners and Engineers
31786 Clarita
Livonia, Michigan 48152
Tel: (313) 575-0220
jsaad.hec@gmail.com

JOB No.
25-2025
SHEET No.
C-1